

PLAN NOTES:

- REFER TO SHEET C0.1 & C0.2 FOR UTILITY AND MISC. CONSTRUCTION NOTES.
- REFER TO SHEET C2.3 FOR UTILITY & MISCELLANEOUS CONSTRUCTION DESIGN & DETAILS.
- THE CONTRACTOR SHALL BE RESPONSIBLE TO ENSURE THAT ALL EXISTING IMPROVEMENTS (MANHOLE LIDS, VAULTS, TRAFFIC BOXES, ETC...) ARE ADJUSTED SO THAT THEY ARE FLUSH WITH THE NEW SIDEWALKS AND PAVEMENT.
- UNLESS SPECIFICALLY IDENTIFIED ALL TWO-WAY CLEANOUTS, AT BUILDING ENTRY POINTS, SHALL BE A MINIMUM OF 4.5' BELOW THE FINISH FLOOR ELEVATION.
- UNLESS SPECIFICALLY IDENTIFIED ALL BEDDING OF UTILITIES SHALL BE TYPE "D" IN NON-STRUCTURAL AREAS (SEE SHEET C2.3 FOR BEDDING/BACKFILL DETAILS).
- PVC SLEEVING SHALL BE COORDINATED ON-SITE WITH THE GENERAL CONTRACTOR.
- THE CONTRACTOR SHALL INSTALL ALL PRE-SLAB INSTALLATIONS & THE DEVELOPER SHALL PAY ALL TAP & METER FEES.
- BACKFLOW PREVENTOR RISER, FOR FIRE SPRINKLER SYSTEMS, IS LOCATED IN THE BUILDING'S MECHANICAL CLOSET.
- CLEANOUT SPACING, ALONG PRIVATE SEWER SERVICES, SHALL NOT EXCEED 100'.
- MANHOLES DESIGNATED AS "PRIVATE" SHALL NOT HAVE COB MANHOLE LIDS.
- THE CONTRACTOR IS RESPONSIBLE FOR CONTACTING THE CITY OF BRYAN ENGINEERING INSPECTOR TO SCHEDULE INSPECTIONS ON THE PUBLIC INFRASTRUCTURE.

UTILITY DEMAND SUMMARY:

USE	PEAK AVG. (x4.0)
SEWER (gpd)	36,640
WATER (gpm)	70
IRRIGATION (gpm)	45

UTILITY DEMAND NOTES:

- PEAK WATER IS DETERMINED BY THE BUILDING CODE - FIXTURE COUNT METHOD AS SUPPLIED BY THE M.E.P.
- SANITARY SEWER AVERAGE DAILY FLOW IS DETERMINED BY DRAINAGE FIXTURE UNITS AS SUPPLIED BY THE M.E.P.
- IRRIGATION DEMAND IS THE PEAK DEMAND AT THE LARGEST ZONE. VERIFY WITH IRRIGATOR

FIRE CODE
 4-STORY (49'-10" MAX) GROSS AREA = 62,279 SQ.FT.
 FIRE CODE: TYPE VA
 50% REDUCTION FOR FIRE SPRINKLER SYSTEM
 HYDRANT: 2 HYDRANTS @ >2,250 GPM (TOTAL)

FIRE CODE:
 THE BUILDING WILL BE PROTECTED WITH AN AUTOMATIC FIRE SPRINKLER SYSTEM. FIRE PROTECTION PER BUILDING IS AS NOTED ABOVE PER THE IFC (TABLE B105.1 & C105.1). FIRE FLOW FOR THE BUILDING IS BASED ON SQUARE-FOOTAGES AND FIRE CONSTRUCTION TYPE.

UTILITY # LEGEND


①	TIE INTO EXISTING 8" WATER LINE 1-8"x4" (MJ) TEE 1-4" (MJ) GATE VALVE & BOX	⑤	94 L.F. OF 2-2" PVC CONDUIT (GREY) w/PULL STRING FOR SECONDARY ELECTRIC SERVICE (36" MIN. COVER) - MAINTAIN 24" (MIN) HORIZ. SEPARATION w/ALL OTHER UTILITIES & PLACE IN SEPARATE DITCH
②	DOMESTIC METER BANK (SEE DETAIL #1): 1-3" DOMESTIC METER w/B.F.P. 1-4" GATE VALVE & BOX	⑥	446 L.F. OF 3-2" PVC CONDUIT (GREY) w/PULL STRING FOR PRIMARY ELECTRIC SERVICE (48" MIN. COVER) - MAINTAIN 24" (MIN) HORIZ. SEPARATION w/ALL OTHER UTILITIES & PLACE IN SEPARATE DITCH
③	IRRIGATION METER (SEE DETAIL #1): 1-4"x2" TAPPING SLAVE & VALVE 1-2" (90° BEND) 1-1" IRRIGATION METER w/B.F.P. 1-2" GATE VALVE & BOX	⑦	326 L.F. OF 3-2" PVC CONDUIT (GREY) w/PULL STRING FOR PRIMARY ELECTRIC SERVICE (48" MIN. COVER) - MAINTAIN 24" (MIN) HORIZ. SEPARATION w/ALL OTHER UTILITIES & PLACE IN SEPARATE DITCH (SEE BTU PLANS)
④	168 L.F. OF 4" PVC (SCH 40) DOMESTIC SERVICE LINE (24" MIN. COVER)	⑧	BRU PAD MOUNTED TRANSFORMER MAIN SERVICE: 3PH - 277/480V - 4000 AMP
⑨	157 L.F. OF 6" PVC FIRE WATER (C900, DR14) (48" COVER)	⑩	STUB-UP FOR FUTURE TRANSFORMER & PAD
⑪	FREE-STANDING REMOTE F.D.C.	⑪	GAS METER (BY ATMOS): REF. M.E.P. DWGS. FOR LOADS
⑫	50 GALLON GREASE TRAP w/SAMPLING WELL: REF. M.E.P. DWGS. (SEE ATMOS PLANS)	⑫	380 L.F. OF 2" POLYETHYLENE PIPE GAS SERVICE (36" MIN. COVER) (SEE ATMOS PLANS)
⑬	36 L.F. OF 4" PVC (C900, DR14) FIRE SUPPLY LINE (48" MIN. COVER)	⑬	50 GALLON GREASE TRAP w/SAMPLING WELL: REF. M.E.P. DWGS. (SEE ATMOS PLANS)

PVT. SANITARY SEWER PIPE LEGEND

PIPE I.D.	NODE I.D. FROM	NODE I.D. TO	DIA. OR RISE (IN.)	LENGTH (FT)	SLOPE (%)	FLOWLINE DOWNSTREAM (FT.)	FLOWLINE UPSTREAM (FT.)
S1	MH1	MH2	8	46.96	1.00	257.75	258.22
S2	MH2	CO1	8	98.87	1.00	259.99	260.98
S3	MH2	CO2	6	42.80	2.00	260.16	261.02

A# PVT. SANITARY SEWER JUNCTION LEGEND

NODE I.D.	NODE TYPE	RIM/GRATE ELEVATION (FT.)	ADDITIONAL NOTES
MH1	EXISTING PUBLIC MANHOLE	~266.00	
MH2	PRIVATE MANHOLE	~265.07	FLUSH w/PROPOSED PAVEMENT
CO1			

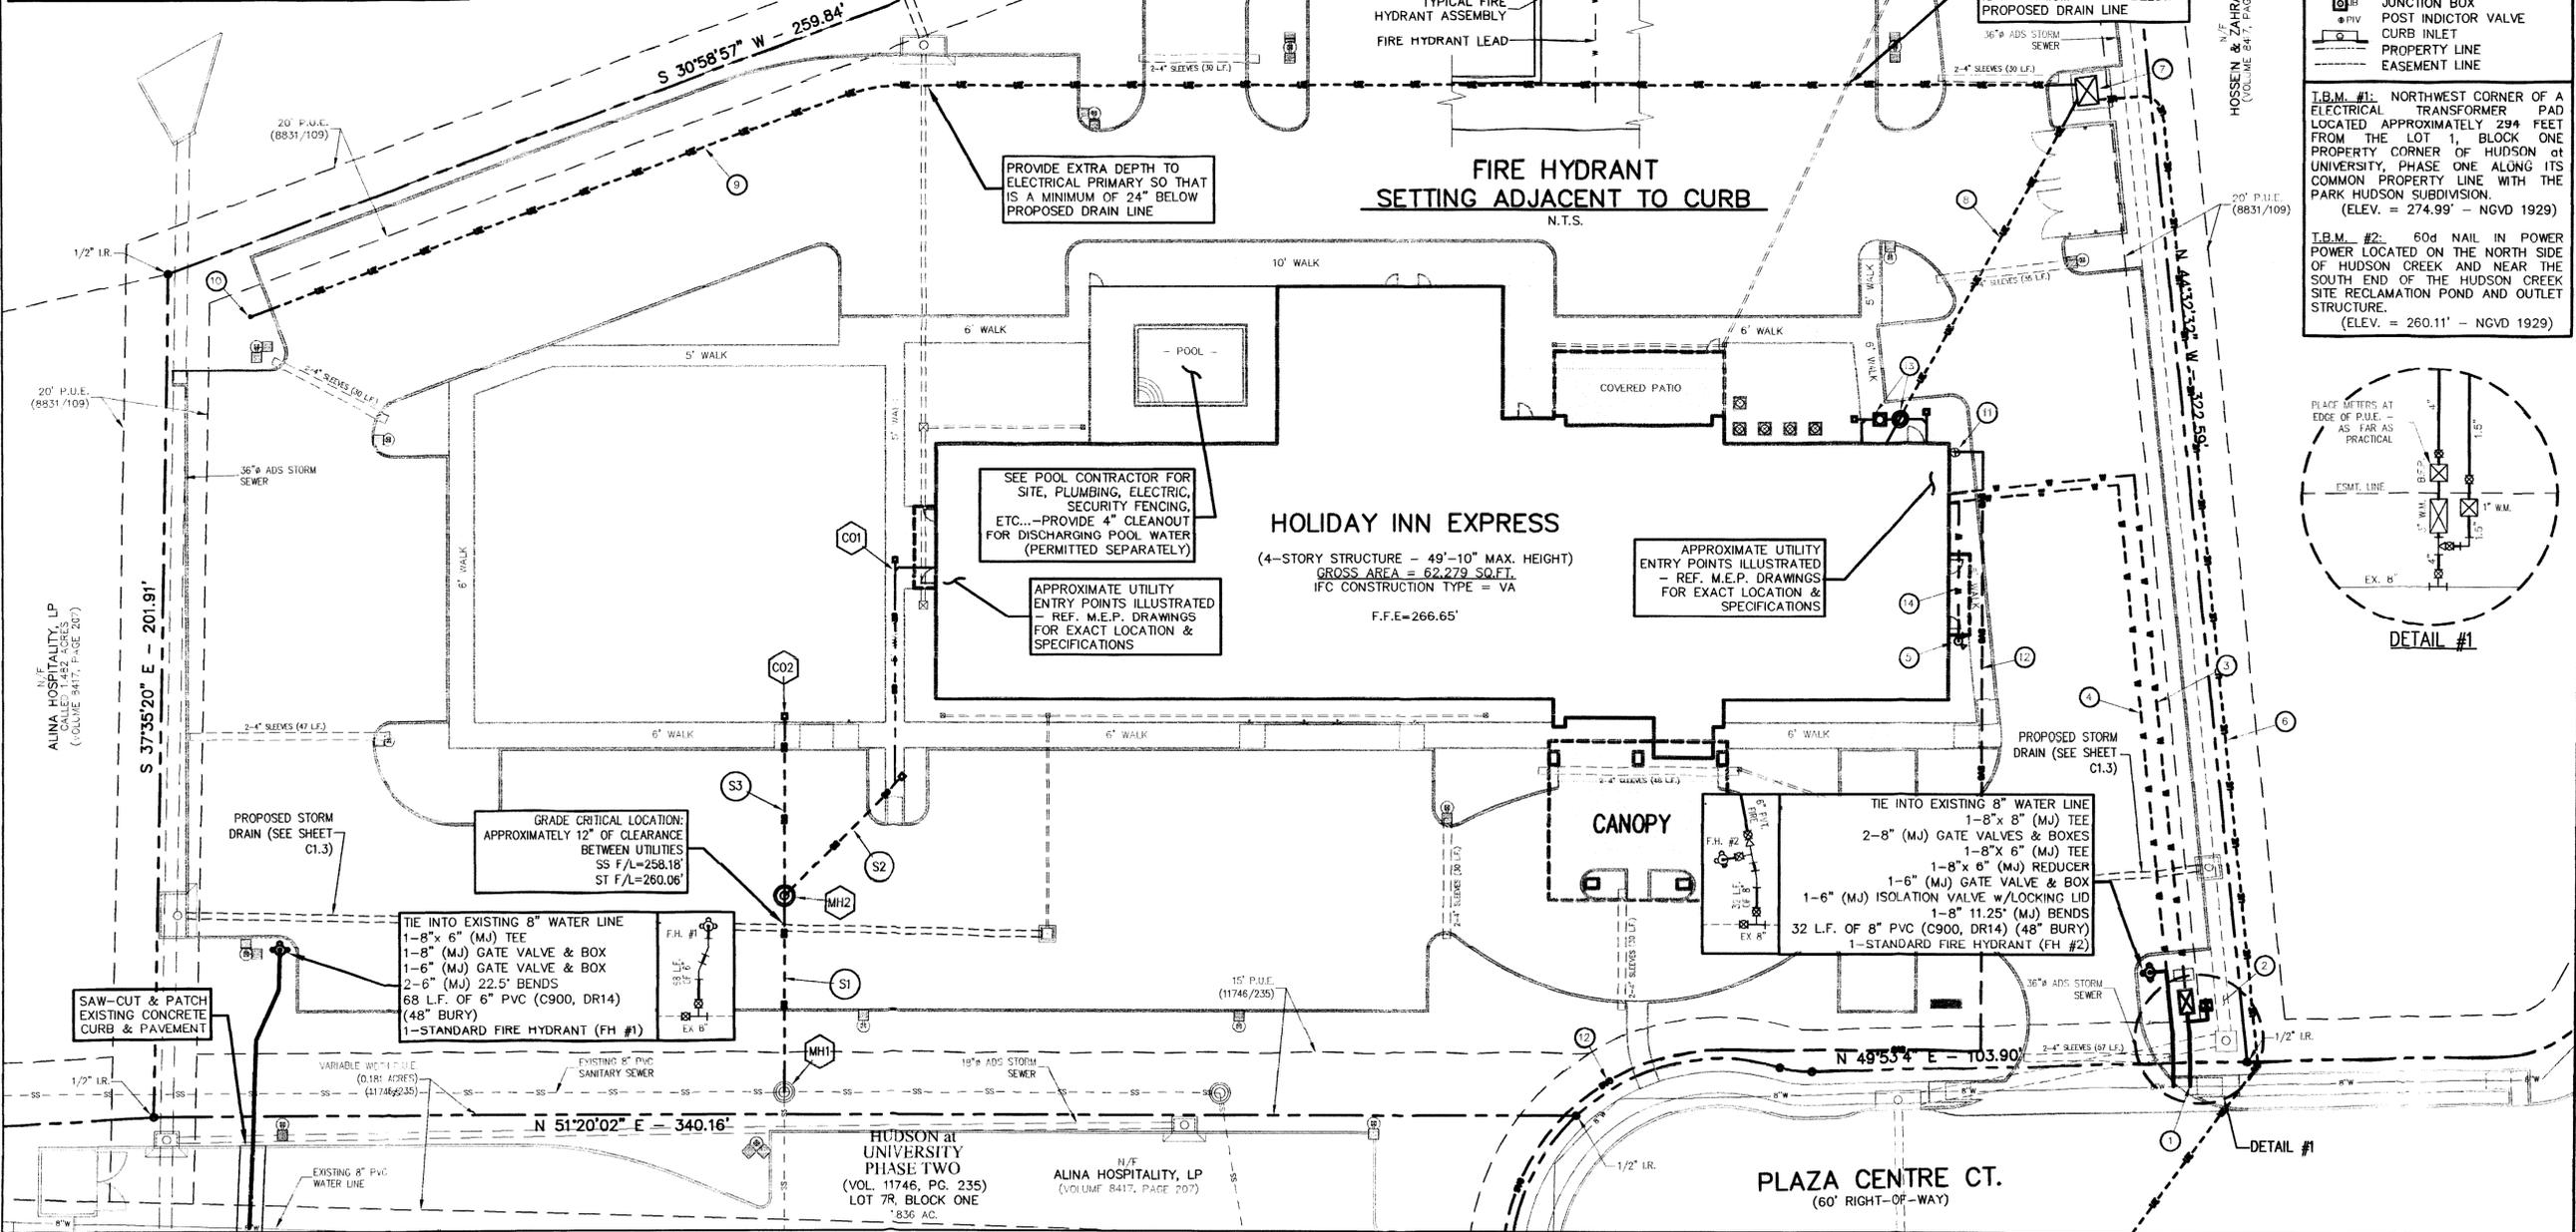


STOP!
 CALL BEFORE YOU DIG
 TEXAS ONE CALL SYSTEM
 1-800-245-4545
 (AT LEAST 72 HOURS PRIOR TO DIGGING)
 WARNING: THE CONTRACTOR IS TO LOCATE ANY AND ALL UTILITIES PRIOR TO CONSTRUCTION AND IS SOLELY RESPONSIBLE FOR ALL DAMAGES TO EXISTING UTILITIES DUE TO ANY CONSTRUCTION ACTIVITY.

SYMBOL & LINE LEGEND

⊙	POWER POLE
⊙	LIGHT POLE
⊙	WATER VALVE
⊙	WATER METER
⊙	BACKFLOW PREVENTOR
⊙	ELECTRICAL SYSTEM
⊙	ELECTRICAL PULL BOX
⊙	ELECTRICAL METER
⊙	GAS METER
⊙	MANHOLE
⊙	CLEANOUT
⊙	FIRE HYDRANT
⊙	TELEPHONE PEDESTAL
⊙	AREA INLET
⊙	JUNCTION BOX
⊙	POST INDICATOR VALVE
⊙	CURB INLET
---	PROPERTY LINE
---	EASEMENT LINE

I.B.M. #1: NORTHWEST CORNER OF A ELECTRICAL TRANSFORMER PAD LOCATED APPROXIMATELY 294 FEET FROM THE LOT 1 BLOCK ONE PROPERTY CORNER OF HUDSON at UNIVERSITY, PHASE ONE ALONG ITS COMMON PROPERTY LINE WITH THE PARK HUDSON SUBDIVISION. (ELEV. = 274.99' - NGVD 1929)

I.B.M. #2: 60d NAIL IN POWER POLE LOCATED ON THE NORTH SIDE OF HUDSON CREEK AND NEAR THE SOUTH END OF THE HUDSON CREEK SITE RECLAMATION POND AND OUTLET STRUCTURE. (ELEV. = 260.11' - NGVD 1929)

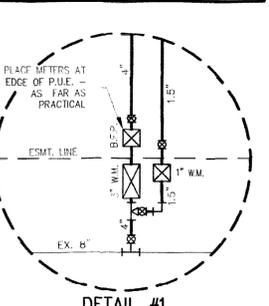

RME Consulting Engineers
 3800 S.H. No. 6 SOUTH, STE. 108G -77845- POST OFFICE BOX 9253 COLLEGE STATION, TEXAS 77842
 EMAIL: civil@rmeengineer.com
 OFFICE: (979) 764-0704
 FAX: (979) 764-0704
 TEXAS FIRM REGISTRATION No. F-4695

SURVEYOR
 KERR SURVEYING, LLC
 409 NORTH TEXAS AVENUE
 BRYAN, TX 77803
 OFF: (979) 268-3195
 FAX: (979) 691-6904

MARK	DATE	DESCRIPTION

STANTIALLY COMPLETE ISSUED FOR CONSTRUCTION 5/18/16

CONSTRUCTION DRAWINGS ISSUED PRIOR TO THIS DATE ARE REPLACED BY THIS SET & SHOULD NOT BE USED FOR CONSTRUCTION.



ON-SITE UTILITY PLAN
 FOR THE
HOLIDAY INN EXPRESS
3041 PLAZA CENTRE CT.
BRYAN, TX
 LOT 6R, BLOCK ONE - HUDSON at UNIVERSITY, PH 2
 BRAZOS COUNTY, TEXAS

CLIENT INFORMATION
 TEXAS HOTEL MANAGEMENT, LP
 c/o SALIM ISMAIL
 P.O. BOX 2864
 BRYAN, TX 77805
 PH: (979) 574-3501
 EMAIL: sismail1004@hotmail.com

FILENAME: 053001A SCALE: 1"=20'
 SUBMITTED DATE: 2/24/16, 3/16/16, 5/18/16

DRAWN BY: R.A.M. CHECKED BY: R.A.M.
 FIELD BOOK: N/A PAGES: N/A

RME CONSULTING ENGINEERS
 CLIENT NO. PROJECT NO.
281 - 0535

C1.4
 SHEET 8 OF 14