



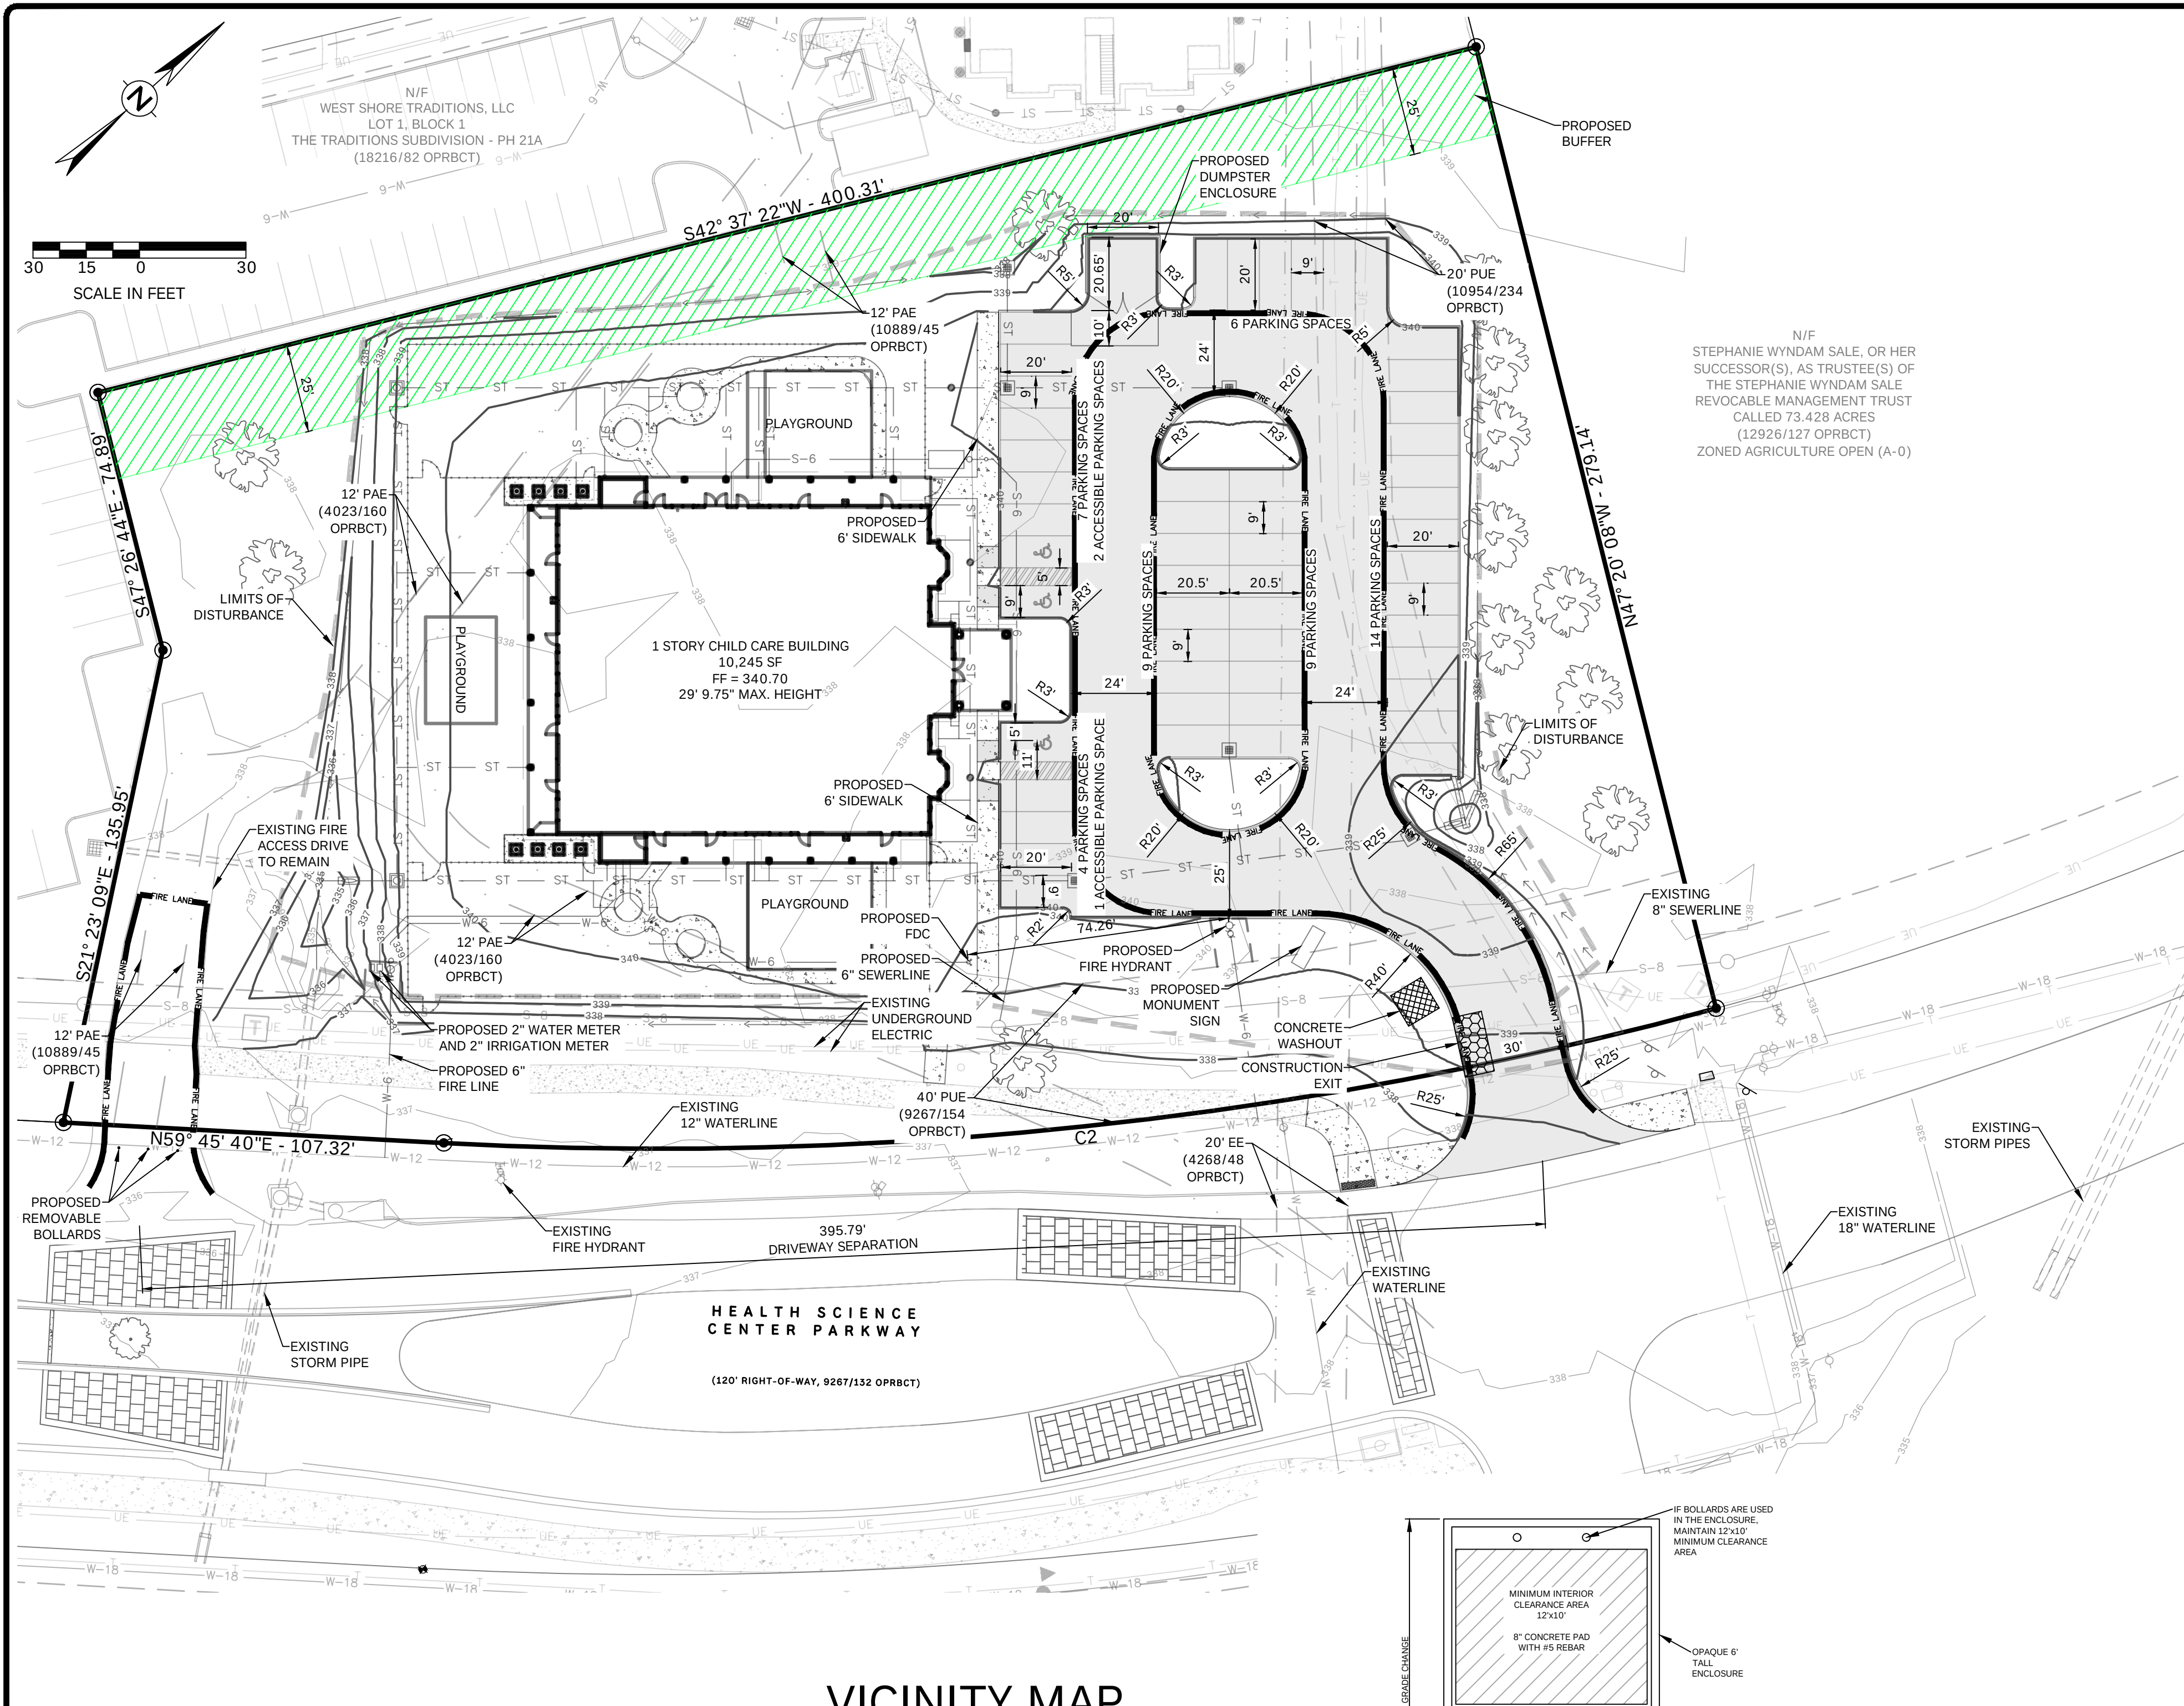

LEGEND	
---	PROPOSED CONTOUR
---	EXISTING CONTOUR
---	PROPERTY BOUNDARY
---	ADJACENT PROPERTY BOUNDARY
---	RIGHT OF WAY (ROW)
---	LOT LINE
---	PROPERTY SETBACK
---	PROPOSED PUBLIC UTILITY EASEMENT (PUE)
---	EXISTING PUBLIC UTILITY EASEMENT (PUE)
---	PROPOSED PUBLIC ACCESS EASEMENT (PAE)
---	EXISTING PUBLIC ACCESS EASEMENT (PAE)
---	PROPOSED PRIVATE ACCESS EASEMENT (PAE)
---	EXISTING PRIVATE ACCESS EASEMENT (PAE)
---	PROPOSED PUBLIC DRAINAGE EASEMENT (PDE)
---	EXISTING PUBLIC DRAINAGE EASEMENT (PDE)
---	PROPOSED PRIVATE DRAINAGE EASEMENT (PDE)
---	EXISTING PRIVATE DRAINAGE EASEMENT (PDE)
---	LIMITS OF DISTURBANCE
---	FIRE LANE
---	PROPOSED CURB AND GUTTER
---	EXISTING CURB AND GUTTER
---	FLOW ARROWS
---	STORM PIPE
---	EXISTING STORM PIPE
---	PROPOSED WATER LINE, SIZE NOTED
---	EXISTING WATER LINE, SIZE NOTED
---	PROPOSED SANITARY SEWER LINE, SIZE NOTED
---	EXISTING SANITARY SEWER SERVICE, SIZE NOTED
---	PROPOSED GAS LINE, SIZE NOTED
---	EXISTING GAS LINE, SIZE NOTED
---	PROPOSED UNDERGROUND ELECTRIC LINE
---	EXISTING UNDERGROUND ELECTRIC LINE
---	EXISTING OVERHEAD ELECTRIC LINE

PARKING ANALYSIS	
REQUIRED PARKING	
200 OF PUPILS	
1 SPACE PER 6 PUPILS	
34 SPACES REQUIRED	
25 OF STAFF MEMBERS	
1 SPACE PER 2 STAFF MEMBERS	
13 SPACES REQUIRED	
5 SPACES FOR DROPOFF	
TOTAL REQUIRED: 52 SPACES	
PROPOSED PARKING	
49 SPACES PARKING	
3 SPACES ACCESSIBLE PARKING	
52 SPACES PROVIDED	

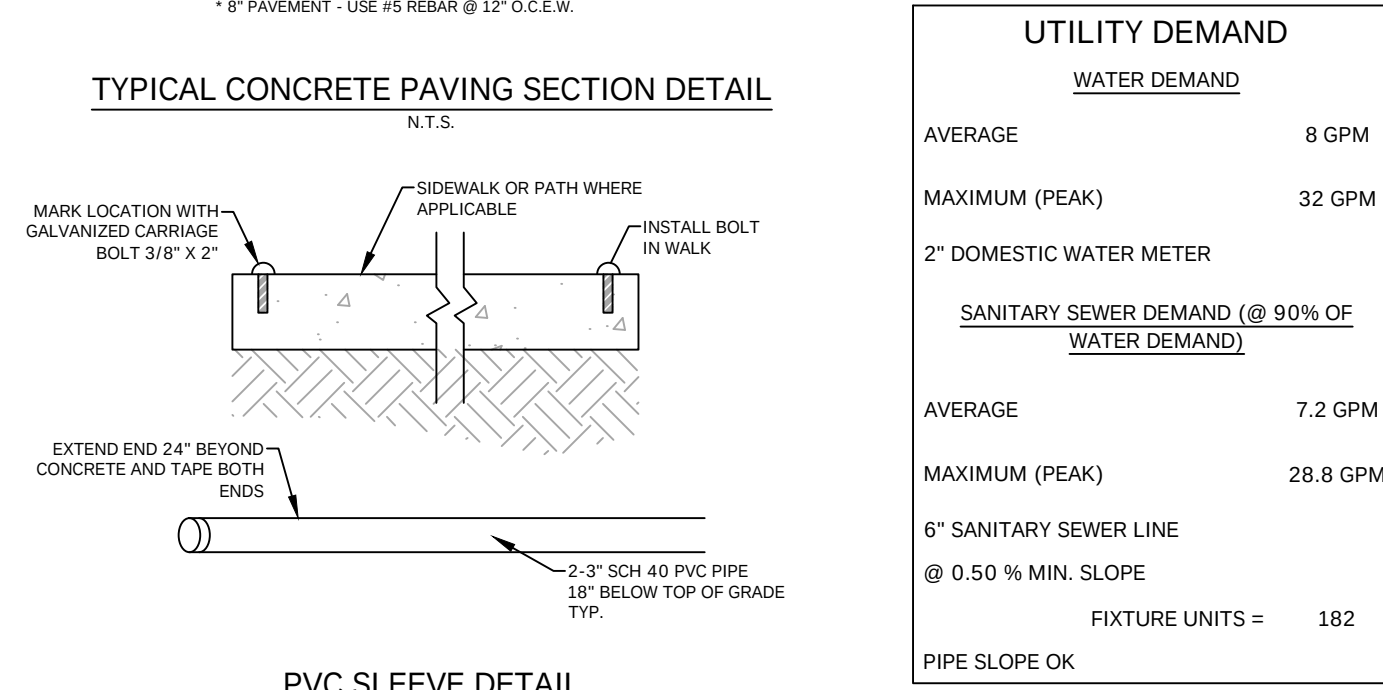

Curve Table						
CURVE #	LENGTH	RADIUS	DELTA	TANGENT	CHORD	CHORD DIRECTION
C2	362.11'	1138.63'	018°13'16"	182.59'	360.58'	N50°39'41'E

CREATIVE WORLD SCHOOL

HEALTH SCIENCE CENTER PARKWAY

TOTAL DISTURBED AREA = 1.557 ACRES

TRADITIONS SUBDIVISION

PHASE 21B, BLOCK 1, LOT 2

TOTAL AREA = 2.477

VOL. _____ PG.

JOHN H. JONES SURVEY LEAGUE, A - 26

BRYAN, BRAZOS COUNTY, TEXAS

SCALE: 1"=30'

OCTOBER 2026

OWNER:

BRYAN COMMERCIAL & DEVELOPMENT, INC.

P.O. BOX 1000

BRYAN, TX 77805

DEVELOPER:

BRYAN TRADITIONS LP

2100 TRADITIONS BLVD.

BRYAN, TX 77807

SURVEYOR:

MICHAEL KONETSKI, RPLS NO. 6531

KERR SURVEYING, LLC

1718 BRANCHCREEK DRIVE

BRYAN, TX 77802

(979) 268-3195






ENGINEER:

SCHULTZ ENGINEERING, LLC

PO BOX 11995

COLLEGE STATION, TX 77842

(979) 764-3900

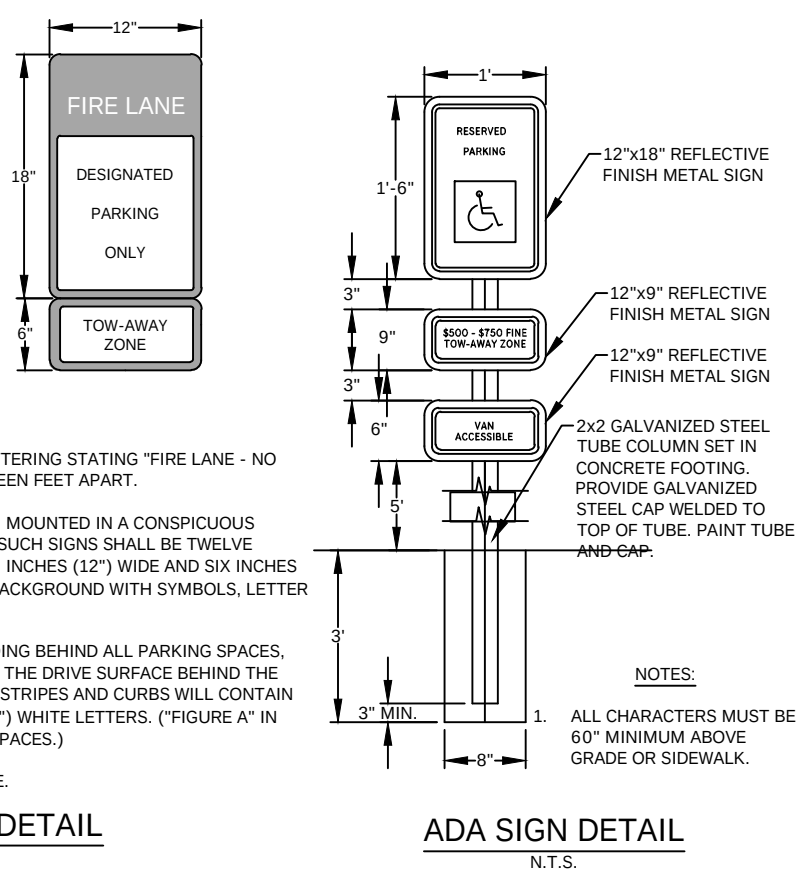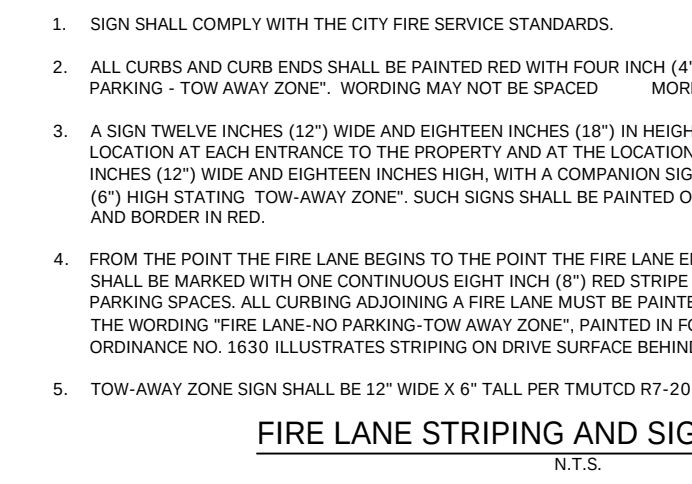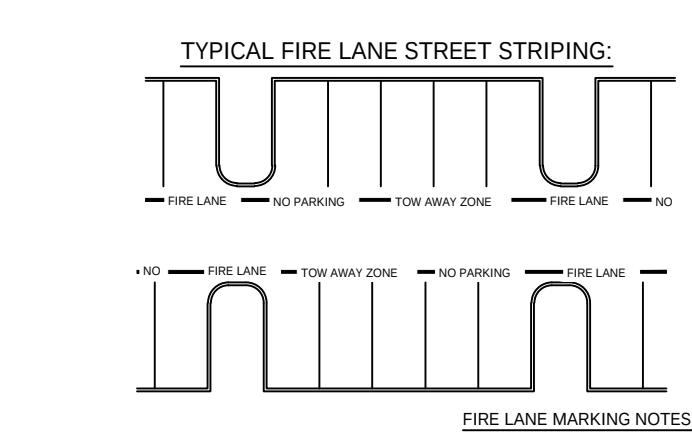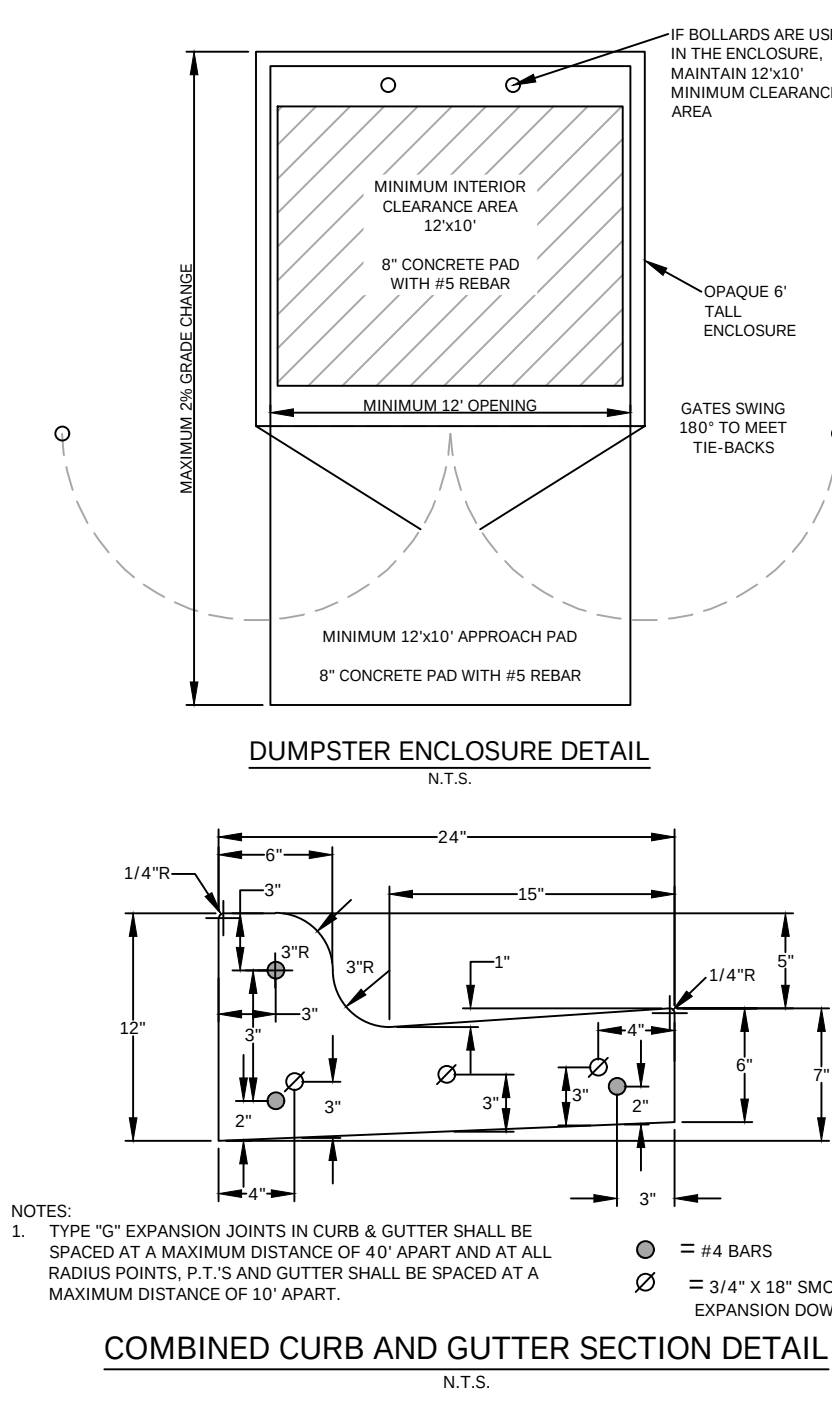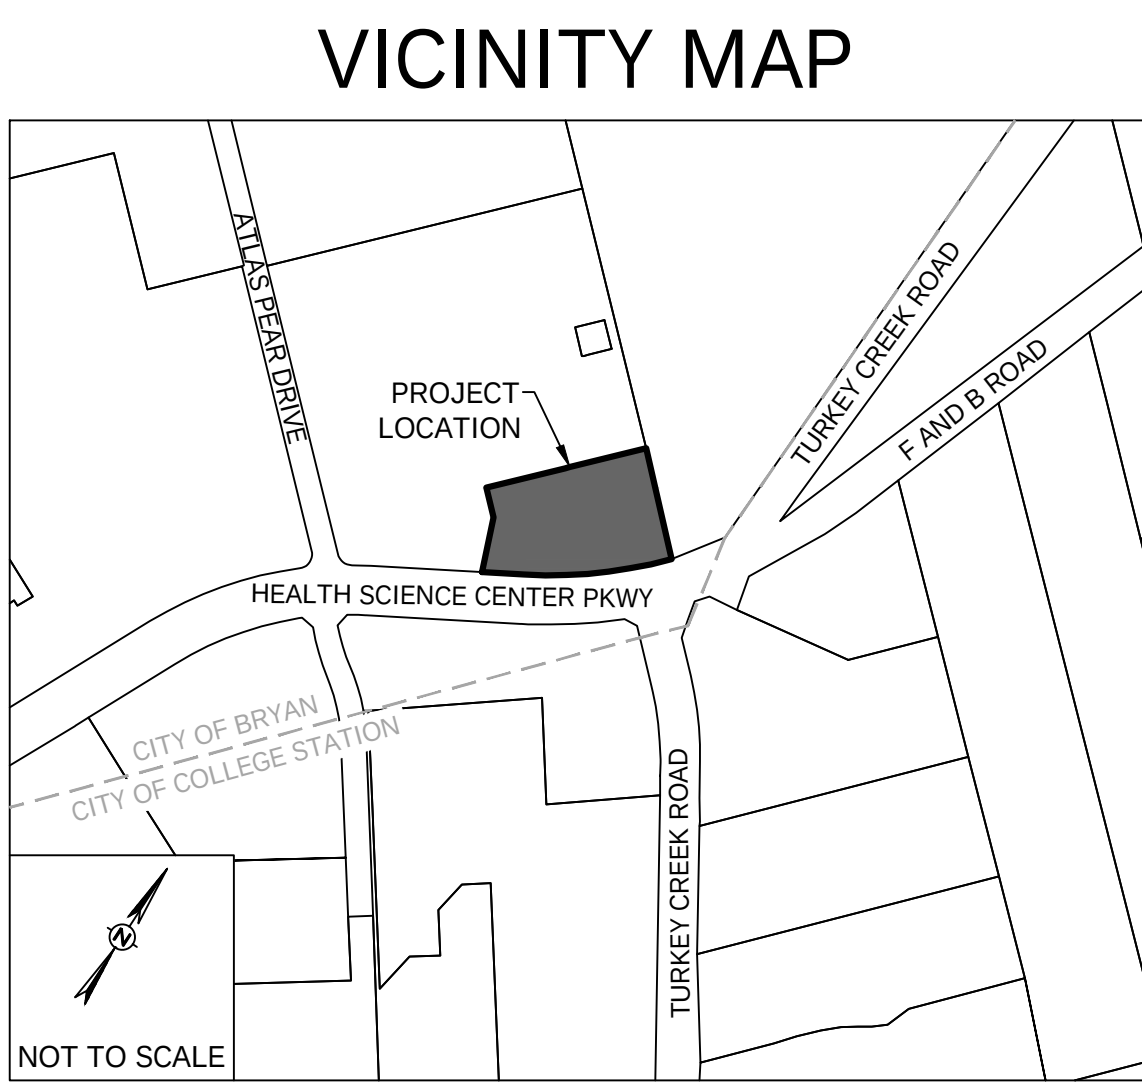

- GENERAL NOTES:
- ALL CONSTRUCTION SHALL BE IN ACCORDANCE WITH THE LATEST CITY OF BRYAN/COLLEGE STATION STANDARD SPECIFICATIONS AND DETAILS FOR WATER, SEWER, STREETS, DRAINAGE. ALL CONSTRUCTION SHALL BE COORDINATED WITH THE CITY ENGINEER'S OFFICE.
 - ALL UTILITY LINES (WATER, GAS, SANITARY SEWER, STORM SEWER, ETC.) SHOWN ARE TAKEN FROM BEST AVAILABLE RECORD INFORMATION BASED ON CONSTRUCTION UTILITY MAP DOCUMENTS OBTAINED FROM CITY & INDEPENDENT AGENCIES AND/OR ABOVE GROUND FIELD EVIDENCE. SHOWN POSITIONS MAY NOT REPRESENT AS-BUILT CONDITIONS.
 - THE CONTRACTOR SHALL BE RESPONSIBLE FOR VERIFYING THE EXACT LOCATION OF ALL EXISTING UNDERGROUND UTILITIES. NOTIFICATION OF THE UTILITY COMPANIES 48 HOURS IN ADVANCE OF CONSTRUCTION IS REQUIRED.
 - THE CONTRACTOR SHALL SETUP A PRE-CONSTRUCTION MEETING WITH BTU PRIOR TO THE START OF ELECTRICAL INFRASTRUCTURE CONSTRUCTION.
 - THE CONSTRUCTION SHALL COMPLY WITH OSHA STANDARD 29 CFR PART 1926 SUBPART P FOR TRENCH SAFETY REQUIREMENTS.
 - BUILDING SETBACK SHALL BE IN ACCORDANCE WITH THE CITY OF BRYAN LAND AND SITE DEVELOPMENT ORDINANCE.
 - PROPOSED SIGNS SHALL BE PERMITTED SEPARATELY IN ACCORDANCE WITH THE SIGN ORDINANCE.
 - IT IS THE RESPONSIBILITY OF THE CONTRACTOR TO USE WHATEVER MEANS NECESSARY TO MINIMIZE EROSION AND PREVENT SEDIMENT FROM LEAVING THE PROJECT SITE. THIS INCLUDES THE INSTALLATION OF A CONSTRUCTION EXIT AND SILT FENCE AS NECESSARY.
 - THE CONTRACTOR IS REQUIRED TO MAINTAIN THE TPDES GENERAL PERMIT NO. TXR 150000 REQUIREMENTS FOR CONSTRUCTION SITES.
 - ALL AREAS WHERE EXISTING VEGETATION AND GRASS COVER HAVE BEEN DISTURBED BY CONSTRUCTION SHALL BE ADEQUATELY BLOCK SODDED OR HYDROMULCHED, AND WATERED UNTIL GROWTH IS ESTABLISHED. IN DEVELOPED AREAS WHERE GRASS IS PRESENT, BLOCK SOD WILL BE REQUIRED. BARE AREAS SHALL BE SEEDED OR SODDED WITHIN 14 CALENDAR DAYS OF LAST DISTURBANCE.
 - DRAINAGE INFORMATION AND DETAILS WILL BE PROVIDED ON THE DRAINAGE PLAN AND DRAINAGE REPORT.
 - LANDSCAPING AND IRRIGATION DESIGN & ANALYSIS WILL BE PROVIDED ON THE LANDSCAPE & IRRIGATION PLANS. THE IRRIGATION SYSTEM MUST BE APPROVED AND INSTALLED PRIOR TO CERTIFICATE OF OCCUPANCY.
 - ALL RADII AND DISTANCES ARE MEASURED TO THE BACK OF CURB UNLESS OTHERWISE NOTED.
 - ALL PAVEMENT SHALL BE PER TYPICAL PAVEMENT SECTION. REFER TO PAVEMENT PLAN FOR PAVEMENT DEPTHS.
 - THE CONTRACTOR SHALL PROMPTLY NOTIFY THE ENGINEER OF ANY DISCREPANCIES IN THESE PLANS, DRAWINGS AND SPECIFICATIONS.
 - IT IS THE RESPONSIBILITY OF THE CONTRACTOR TO COMPLY WITH ALL STATE AND FEDERAL REGULATIONS REGARDING CONSTRUCTION ACTIVITIES NEAR ENERGIZED OVERHEAD POWER LINES.
 - THE CONTRACTOR SHALL BE RESPONSIBLE FOR THE PROTECTION OF ALL EXISTING UTILITIES OR SERVICE LINES THAT ARE CROSSED OR EXPOSED DURING CONSTRUCTION OPERATIONS. WHERE EXISTING UTILITIES OR SERVICE LINES ARE CUT, BROKEN, OR DAMAGED, THE CONTRACTOR SHALL REPAIR OR REPLACE THE UTILITIES OR SERVICE LINE WITH THE SAME TYPE OF MATERIAL AND CONSTRUCTION OR BETTER. THIS MATERIAL AND WORK SHALL BE AT THE CONTRACTOR'S OWN EXPENSE.
 - A COPY OF THE APPROVED CONSTRUCTION PLANS MUST BE KEPT ON SITE AT ALL TIMES THROUGHOUT THE ENTIRE CONSTRUCTION OF THE PROJECT. CONTRACTOR SHALL MAINTAIN A SET OF REDLINE DRAWINGS, RECORDING AS-BUILT CONDITIONS DURING CONSTRUCTION.
 - ANY ADJACENT PROPERTY AND RIGHT-OF-WAY DISTURBED DURING CONSTRUCTION WILL BE RETURNED TO THEIR EXISTING CONDITION OR BETTER.
 - THE CONTRACTOR SHALL NOT CREATE A DIRT NUISANCE OR SAFETY HAZARD IN ANY STREET OR DRIVEWAY.
 - ADEQUATE DRAINAGE SHALL BE MAINTAINED AT ALL TIMES DURING CONSTRUCTION AND ANY DRAINAGE DITCH OR STRUCTURE DISTURBED DURING CONSTRUCTION SHALL BE RESTORED TO EXISTING CONDITIONS OR BETTER.
 - THE CONTRACTOR SHALL PROTECT ALL MONUMENTS, IRON PINS, AND PROPERTY CORNERS DURING CONSTRUCTION.
 - THE IRRIGATION SYSTEM WILL BE PROTECTED BY EITHER A PRESSURE VACUUM BREAKER, A REDUCED PRESSURE PRINCIPLE BACK FLOW DEVICE, OR A DOUBLE-CHECK BACK FLOW DEVICE, AND INSTALLED AS PER CITY ORDINANCE 2384.
 - THE CONTRACTOR MAY OBTAIN AN ELECTRONIC COPY OF THESE PLANS FOR CONSTRUCTION PURPOSES. THE ELECTRONIC FILE AND INFORMATION GENERATED BY SCHULTZ ENGINEERING, LLC (SE) FOR THIS PROJECT IS CONSIDERED BY SE TO BE CONFIDENTIAL. WHEN ISSUED, IT'S USE IS INTENDED SOLELY FOR THE INDIVIDUAL OR ENTITY TO WHICH IT IS ADDRESSED. PERMISSION IS NOT GRANTED TO THE RECIPIENT FOR DISTRIBUTION OF THESE DOCUMENTS IN ANY FORM OR FASHION. THE RECIPIENT UNDERSTANDS THAT THIS DATA IS AUTHORIZED "AS IS" WITHOUT ANY WARRANTY, AS TO IT'S PERFORMANCE, ACCURACY, FREEDOM FROM ERROR, OR AS TO ANY RESULTS GENERATED THROUGHOUT ITS USE. THE RECIPIENT AGREES TO UNDERSTAND AND AGREE THAT IT IS UPON RELEASE OF SUCH DATA, IS NO LONGER RESPONSIBLE FOR THEIR USE OR MODIFICATION. THE USER AND RECIPIENT OF THE ELECTRONIC DATA ACCEPTS FULL RESPONSIBILITY AND LIABILITY FOR ANY CONSEQUENCES ARISING OUT OF THEIR USE.
 - CURB DETAILS REFER TO BRYAN - COLLEGE STATION STANDARD STREET DETAILS SHEET (FIGURE: ST, SHEET 1 OF 2).
 - WHERE ELECTRIC FACILITIES ARE INSTALLED, BTU HAS THE RIGHT TO INSTALL, OPERATE, RELOCATE, CONSTRUCT, RECONSTRUCT, ADD TO, MAINTAIN, INSPECT, PATROL, ENLARGE, REPAIR, REMOVE AND REPLACE SAID FACILITIES UPON, OVER, UNDER, AND ACROSS THE PROPERTY INCLUDED IN THE PUE, AND THE RIGHT OF INGRESS AND EGRESS ON PROPERTY ADJACENT TO THE PUE TO ACCESS ELECTRIC FACILITIES.
- SITE SPECIFIC NOTES:
- THE OWNER OF THE PROPERTY IS BRYAN COMMERCIAL & DEVELOPMENT, INC. THE SUBJECT PROPERTY IS TRADITIONS SUBDIVISION PHASE 21B, BLOCK 1, LOT 2. PROPERTY IS ZONED PLANNED DEVELOPMENT DISTRICT (PD).
 - THE TOTAL DISTURBED AREA FOR THIS PROJECT IS 1.557 ACRES (67,839 SF).
 - THIS TRACT LIES WITHIN FLOOD ZONE "X" UNSHADED AND DOES NOT LIE WITHIN A SPECIAL FLOOD HAZARD AREA SUBJECT TO THE 1% ANNUAL CHANCE FLOOD (100 YEAR FLOOD PLAIN) ACCORDING TO THE BRAZOS COUNTY FLOOD INSURANCE RATE MAP (FIRM) PANEL NO. 48044C0285E, REVISED DATE: 05-16-2012 REFERENCED ON 07-22-2026.
 - THE MINIMUM REQUIRED FIRE FLOW FOR A CHILD CARE BUILDING (IBC TYPE VB OF 10,245 SF IS 2,750 GALLONS PER MINUTE. THE BUILDING IS FULLY SPRINKLED WHICH DECREASES THE REQUIRED FIRE FLOW BY 50% (1,375 GPM). ONE FIRE HYDRANT IS REQUIRED. THE EXISTING HYDRANT WILL BE SUFFICIENT.
 - PARKING LOT STRIPING OTHER THAN FIRE LANE STRIPING SHALL CONFORM TO TEXAS DEPARTMENT OF TRANSPORTATION (TxDOT) STANDARD SPECIFICATIONS FOR CONSTRUCTION OF HIGHWAYS, STREETS, AND BRIDGES, ITEM 666, TYPE 2 MARKING MATERIALS.
 - THE FIRE SUPPRESSION LINE SHALL HAVE A LOCKABLE LID ON THE ISOLATION VALVE. THE LOCKABLE LID SHALL SUPPLY THE SAME PROTECTION AS THE AMP OR USA. LOCK LOCKING LID AT MINIMUM. AN ALTERNATING LOCKABLE LID SHALL BE APPROVED BY THE FIRE MARSHALL, OR HIS DESIGNEE.
 - CONTOURS SHOWN ARE FROM FIELD SURVEY DATA.
 - ALL STORM SEWER IS PRIVATE. STORM SEWER COVERS SHALL BE LABELED PRIVATE AND SHALL NOT USE THE CITY OF BRYAN LOGO ON COVERS.
 - THE CONTRACTOR SHALL BE RESPONSIBLE FOR THE CONTAINMENT AND PROPER DISPOSAL OF ALL LIQUID AND SOLID WASTE ASSOCIATED WITH THE CONSTRUCTION OF THIS PROJECT. THE CONTRACTOR SHALL USE ALL MEANS NECESSARY TO PREVENT THE OCCURRENCE OF WIND BLOWN LITTER FROM THE PROJECT SITE.
 - THE CONTRACTOR IS REQUIRED TO PROVIDE CONTAINMENT FOR WASTE, PRIOR TO AND DURING DEMOLITION AND CONSTRUCTION. SOLID WASTE ROLL-OFF BOXES/METAL DUMPSTERS SHALL BE SUPPLIED BY THE CITY OR CITY PERMITTED CONTRACTOR(S) ONLY.
 - NORMAL DOMESTIC WASTEWATER IS ANTICIPATED TO BE DISCHARGED FROM THIS DEVELOPMENT.
 - ALL BACKFLOW DEVICES MUST BE INSTALLED AND TESTED UPON INSTALLATION AS PER CITY ORDINANCE.
 - THE IRRIGATION SYSTEM MUST BE PROTECTED BY EITHER AN ATMOSPHERIC OR A PRESSURE VACUUM BREAKER OR REDUCED PRESSURE PRINCIPLE BACK FLOW DEVICE AND INSTALLED AS PER CITY ORDINANCE.
 - 6" CONCRETE PAVEMENT TO BE PROVIDED FOR DUMPSTER LOCATIONS PER CITY OF BRYAN SPECIFICATIONS. DUMPSTER CONTAINMENT AREAS SHALL BE REINFORCED WITH #5 BARS AT 12" O.C.W. AND THE PAD SHALL EXTEND AN ADDITIONAL 10' IN FRONT OF CONTAINMENT AREA.
 - FIRE SPRINKLER SYSTEM - POTABLE WATER SUPPLY MUST BE PROTECTED BY A TESTABLE DOUBLE CHECK VALVE ASSEMBLY, AND INSTALL AS PER CITY ORDINANCE.
 - ALL DEVICES, APPURTENANCES, APPLIANCES AND APPARATUS INTENDED TO SERVE SOME SPECIAL FUNCTION AND THAT CONNECTS TO THE WATER SUPPLY SYSTEM SHALL BE PROVIDED WITH PROTECTION AGAINST BACKFLOW AND CONTAMINATION OF THE WATER SUPPLY.

911 Southwest Pkwy E.
College Station, Texas 77840
979.764.3900
TBPE FIRM NO. 12327

MARK	REVISION	BY	DATE	KERR	DLD	DLD	JPS	26-490	OCTOBER 2026

THIS DOCUMENT IS RELEASED FOR THE PURPOSE OF REVIEW ONLY UNDER THE AUTHORITY OF DEVEN L. DOYEN P.E., LICENSE NO. 109835, ON OCTOBER 14, 2026. IT IS NOT TO BE USED FOR BIDDING OR CONSTRUCTION PURPOSES.

CREATIVE WORLD SCHOOL
TRADITIONS SUBDIVISION PHASE 21B
BLOCK 1, LOT 2
TRACT 56.180 - BRYAN, TX

SCALE
VERTICAL N/A
HORIZONTAL 1"=30'
PLOTING SCALE: 1:1
FILE NAME: 26-490

SCALE SHEET
C1